


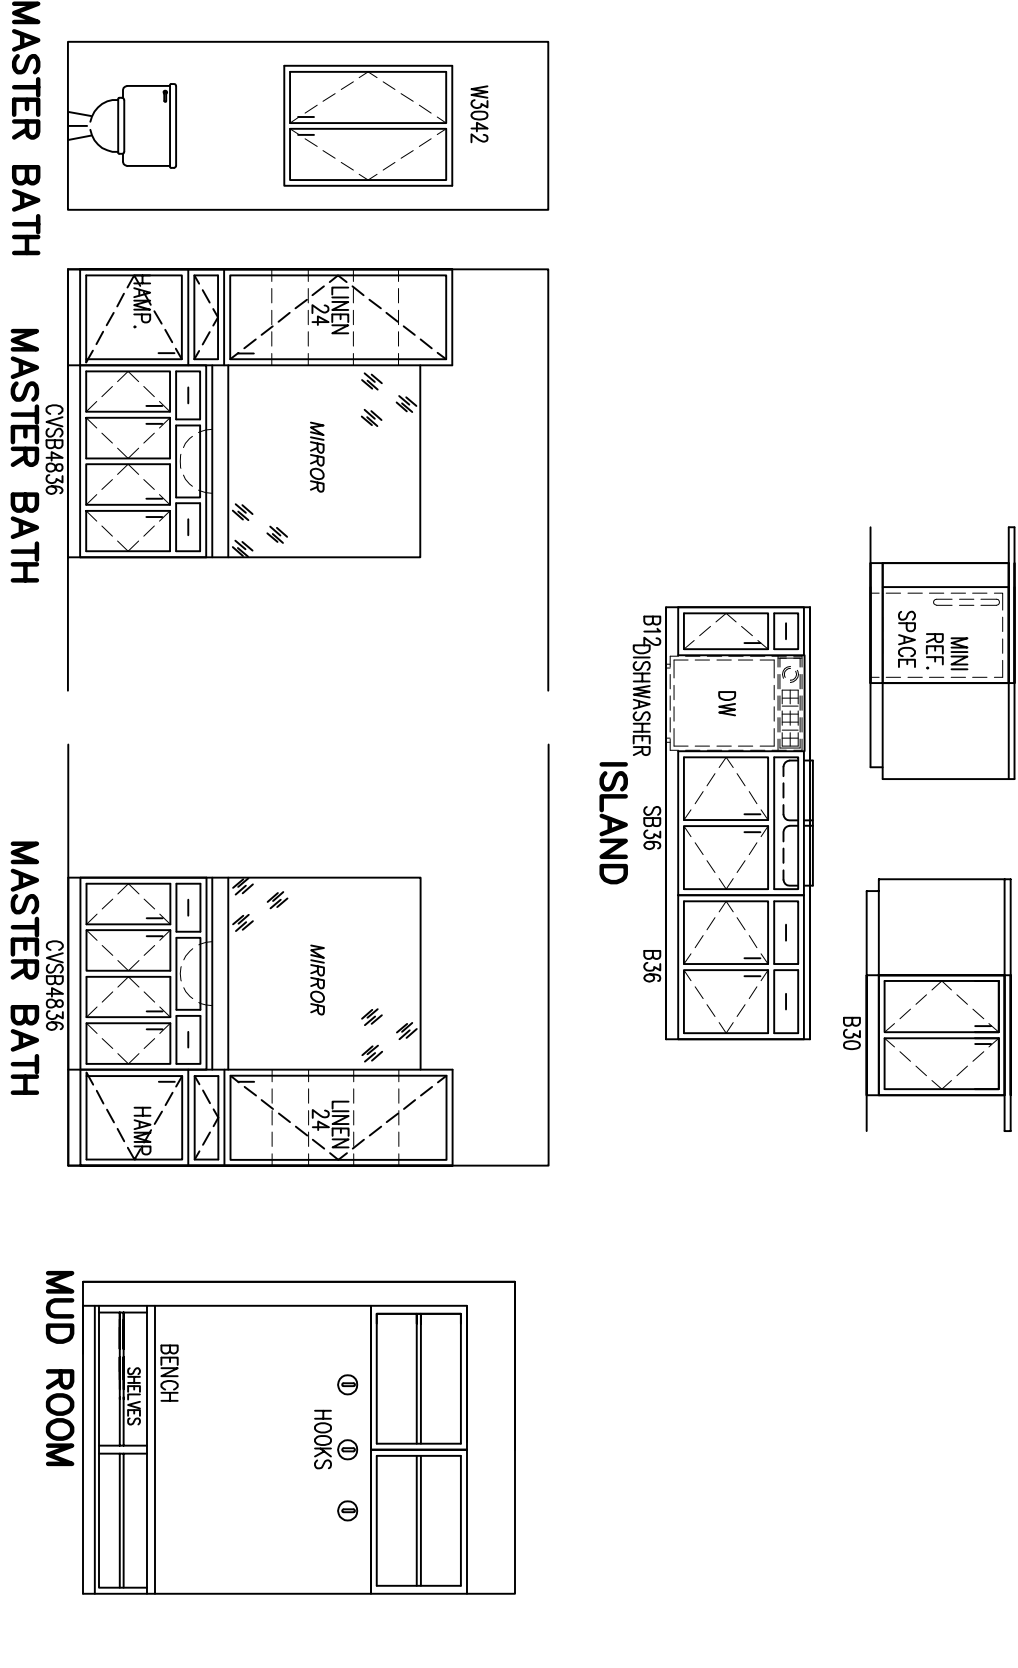

NOTE: HANDRAILS AND GUARDRAILS SHALL COMPLY WITH THE MINIMUM UNIFORMITY DISTRIBUTED LOADS AS PER TABLE R301.4


NOTE: ALL PRECASTS SHALL COMPLY WITH SECTION R301.6 (TERMINATE CHIMNEY 2'-0" ABOVE ANY SURFACE WHEN 10'-0" R317.2

NOTE: SMOKE ALARMS SHALL COMPLY WITH SECTION R317.1 AND R317.2

NOTE: UNDER STAR PROTECTION SHALL COMPLY WITH SECTION R314.8

NOTE: ATTIC STAR SHALL COMPLY WITH SECTION M305.1.3 AS MANDATED BY THE CITY OF SPRING (CLEAR OPENING MIN. 30" x 54")


NOTE: PROVIDE TEMPERED GLAZING PER SECTION R308.4

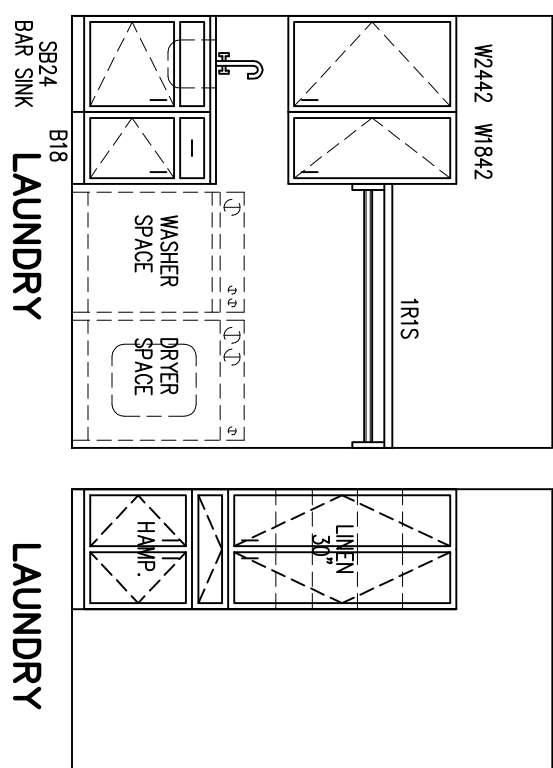

BATH 3

CUB36

Diagram of Bath 3 layout. The room contains a shower, a toilet, and a vanity area with a mirror and cabinets. The shower is located at the top left. The toilet is located at the bottom left. The vanity area is located at the bottom right, featuring a mirror and cabinets. The shower is labeled 'SHOWER' and the toilet is labeled 'TOILET'.


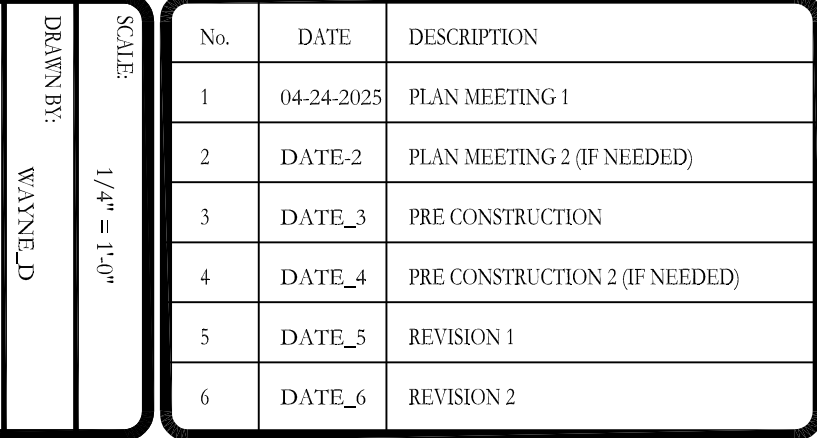


27427 SHADY HILLS LANDING LANE
SPRING, TEXAS 77386
OFFICE (713) 539-3921
FAX (281) 855-9733

SPEC MODEL
ADDRESS
THE CEDARS

FLOOR_1

ELECTRICAL LEGEND	
(ALL RECEPTALS TO BE TAMPER-RESISTANT) PER 2012 IRC	
	110 VOLT RECEPTACLE
	WATERPROOF RECEPTACLE
	110 VOLT IN CLG.
	110 VOLT W/ GROUND FAULT INTERRUPTER
	220 VOLT RECEPTACLE
	TELEVISION ANTENNA
	GAS OUTLET
	HOSE BIB
	TELEPHONE OUTLET
	SINGLE POLE SWITCH
	THREE WAY SWITCH
	FOUR WAY SWITCH
	DIMMER SWITCH
	PUSH BUTTON
	SMOKE DETECTOR
	CARBON DIOXIDE DETECTOR
	THERMOSTAT
	DOORBELL CHIMES
	CEILING MOUNTED LIGHT FIXTURE
	HANGING LIGHT
	LED LIGHT FIXTURE
	RECESSED CAN LIGHT
	WATERPROOF RECESSED CAN LIGHT
	RECESSED EYEBALL SPOT LIGHT
	WALL MOUNTED LIGHT FIXTURE
	PORCELAIN FIXTURE W/ PULL CORD
	FLOOD LIGHTS
	EXHAUST FAN
	EXHAUST FAN W/ LIGHT
	EXHAUST FAN W/ HEAT LAMP
	EXHAUST FAN W/ HEAT LAMP & LT.
	KENLESS CEILING MOUNTED LIGHT FIXTURE
	UNDER COUNTER LIGHT
	ZONE SENSOR
	CEILING FAN
	CEILING FAN W/ LIGHT
	CEILING LIGHT W/ FUTURE FAN
	2X4 FLUORESCENT LIGHT
	1X4 FLUORESCENT LIGHT

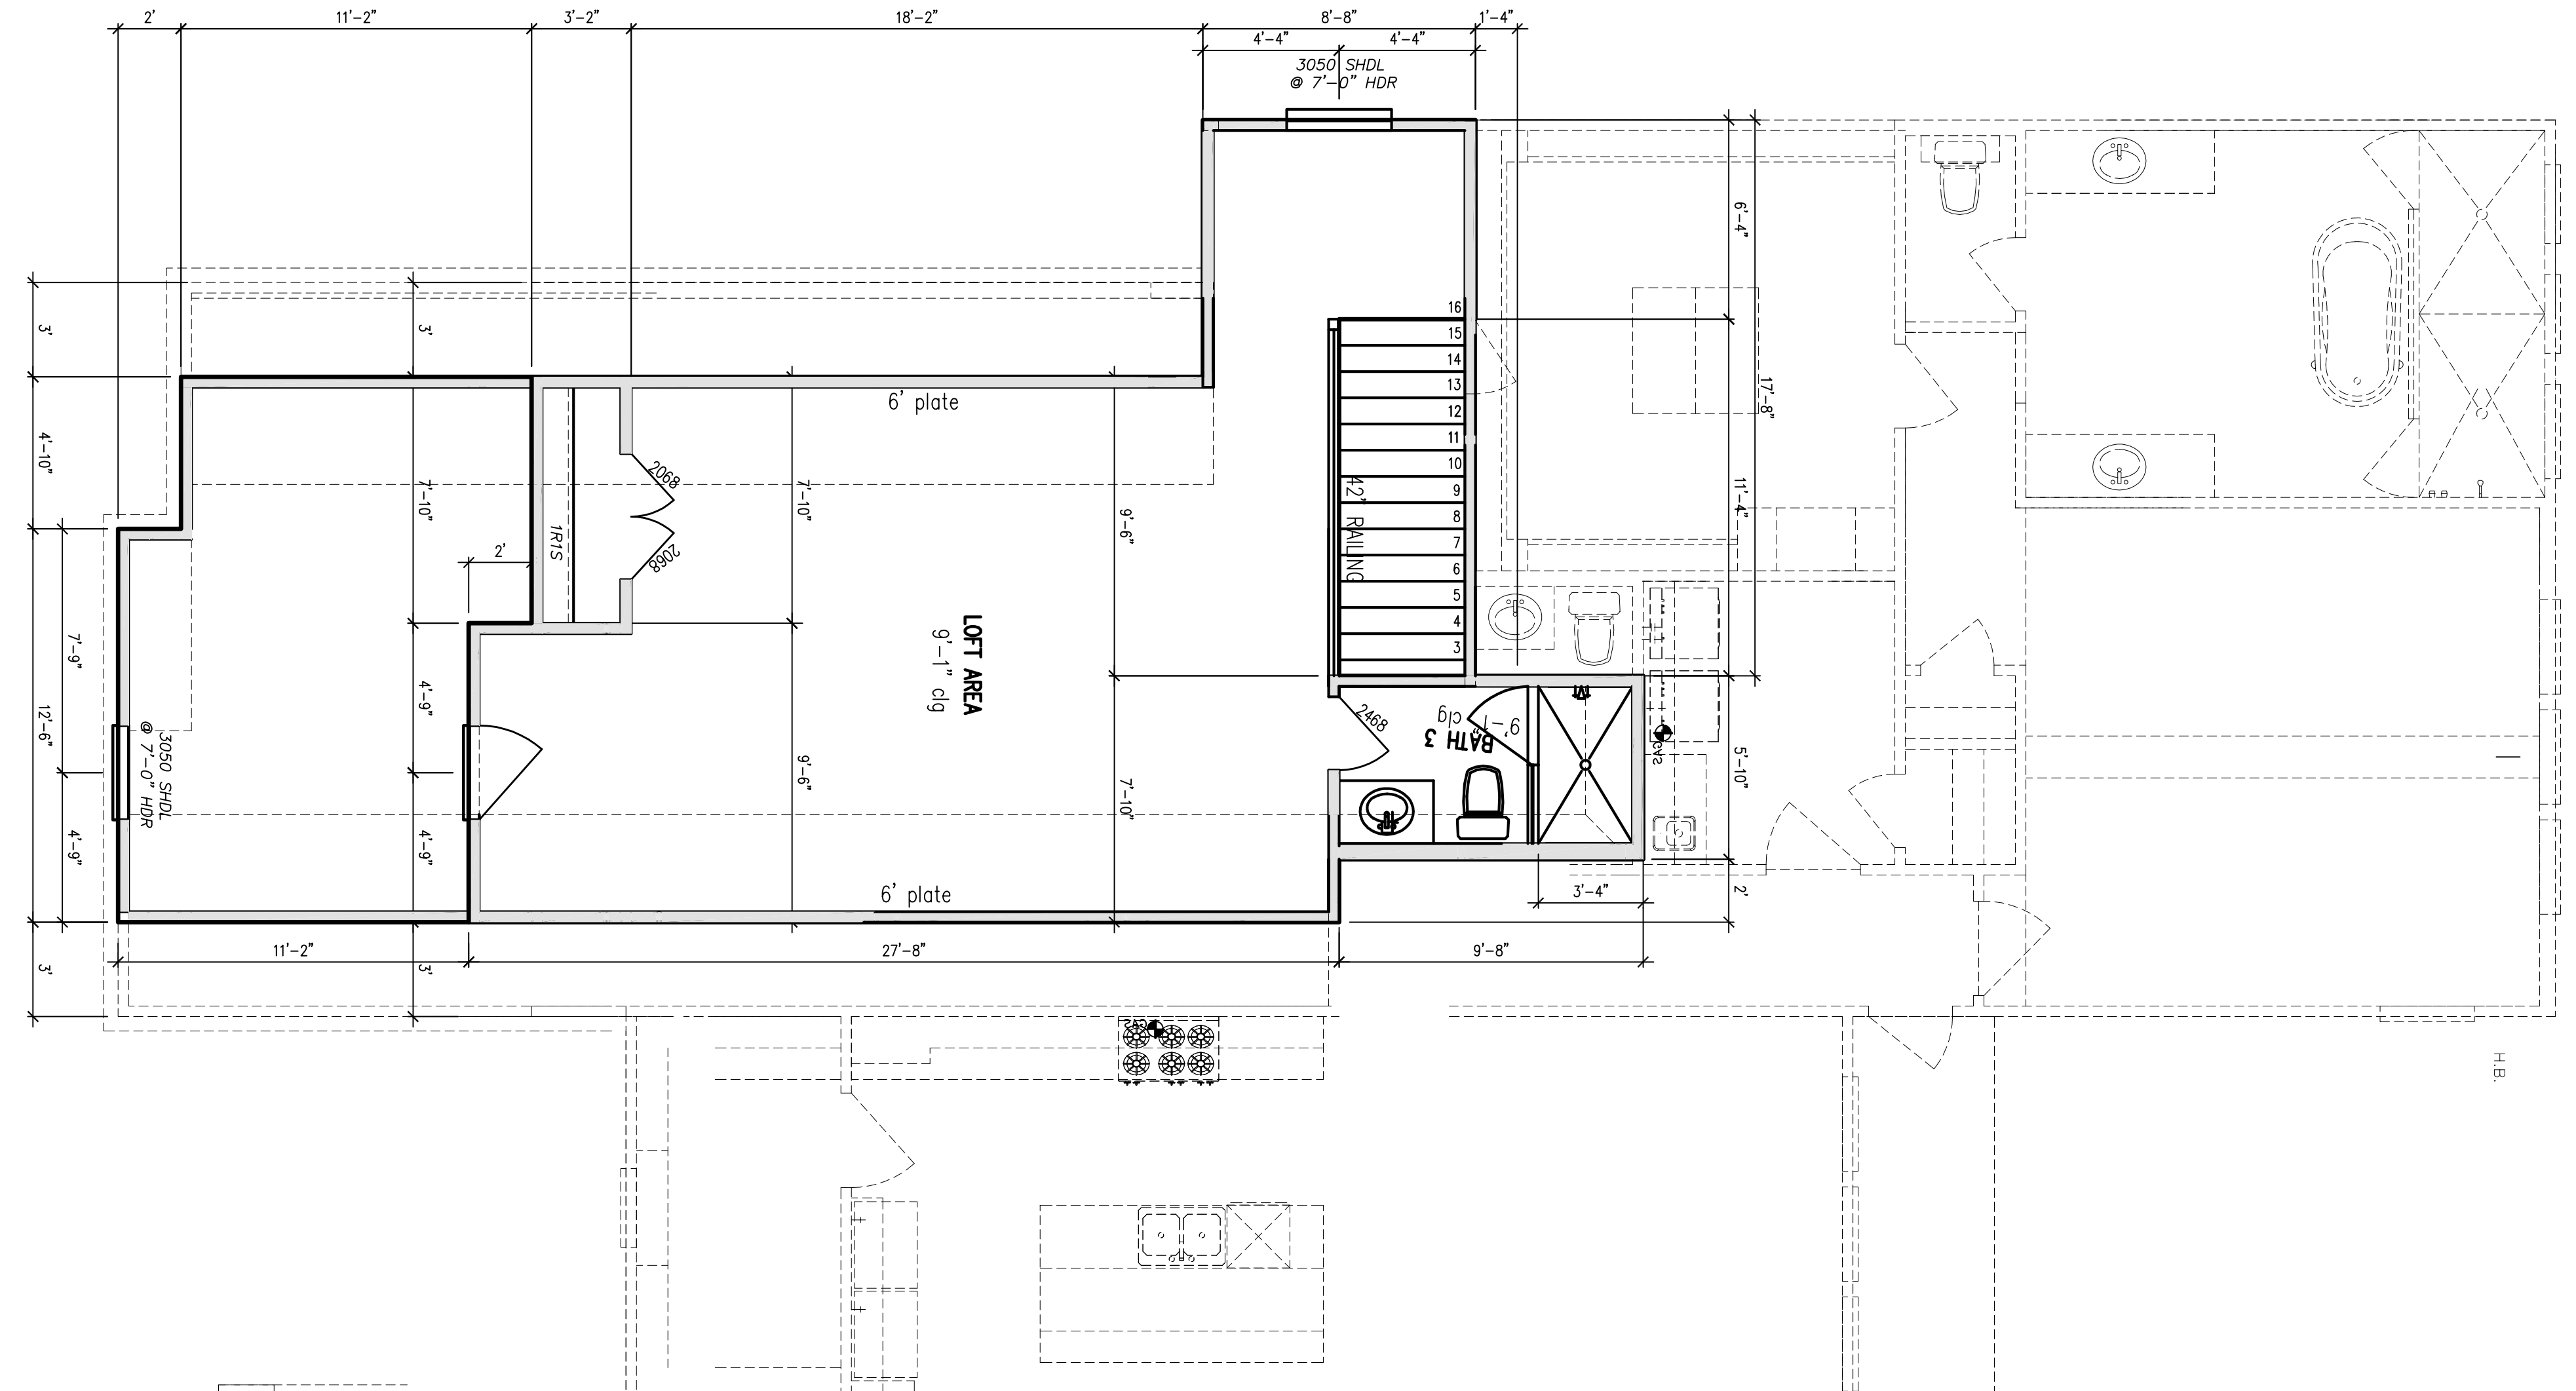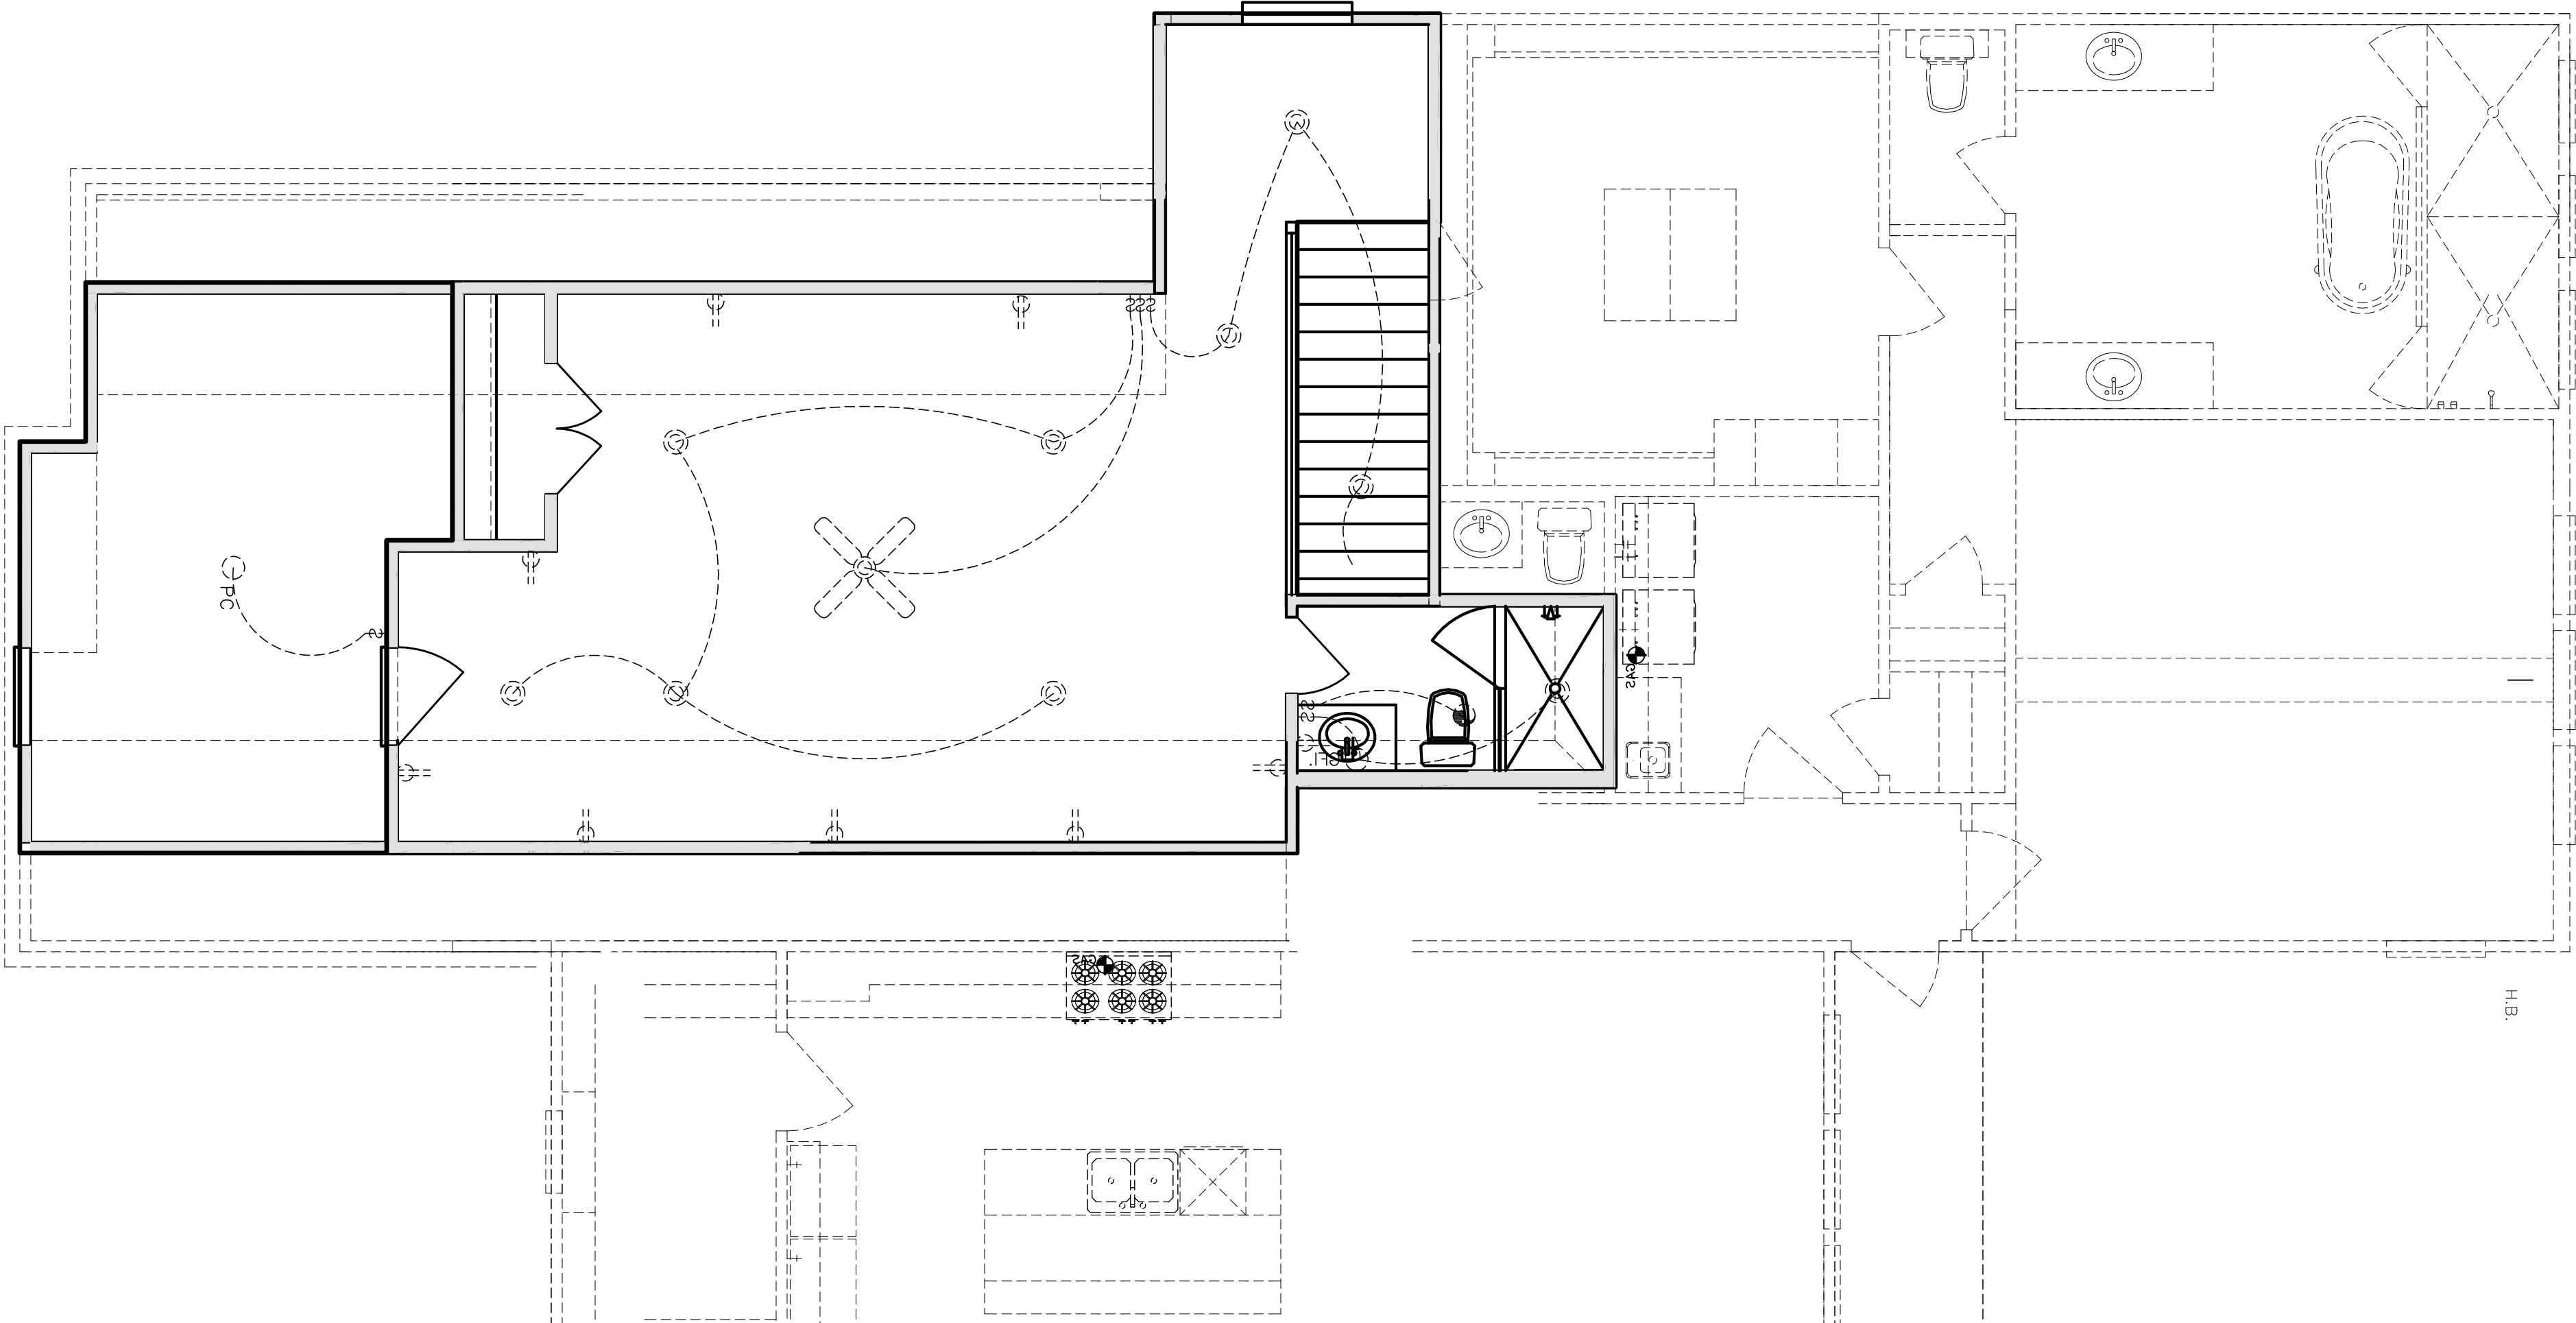

NOTE:
GUARDRAILS AND HANDRAILS TO COMPLY WITH 2006 IRC. 36"
HIGH RAILS W/ BALUSTERS @ 4" O.C. MAX. MUST WITHSTAND MIN.
UNIFORMLY DIST. 200 LBS. PER SQ.FT. LIVE LOADS APPLIED IN ANY
DIRECTION AT ANY POINT ALONG THE TOP OF THE GUARDRAIL
OR HANDRAIL.


No.	DATE	DESCRIPTION
1	DATE_1	PLAN MEETING 1
2	DATE_2	PLAN MEETING 2 (IF NEEDED)
3	DATE_3	PRE CONSTRUCTION
4	DATE_4	PRE CONSTRUCTION 2 (IF NEEDED)
5	DATE_5	REVISION 1
6	DATE_6	REVISION 2

SCALE:	1/4" = 1'-0"
DRAWN BY:	WAYNEJD
CHECKED BY:	
DATE:	10/06/2023
SHEET NO.	FLOOR_2

DROLLETT
DESIGNS


27427 SHADY HILLS LANDING LANE
SPRING, TEXAS 77386
OFFICE (713) 539-3921
FAX (281) 855-9733

SPEC MODEL
ADDRESS
THE CEDARS

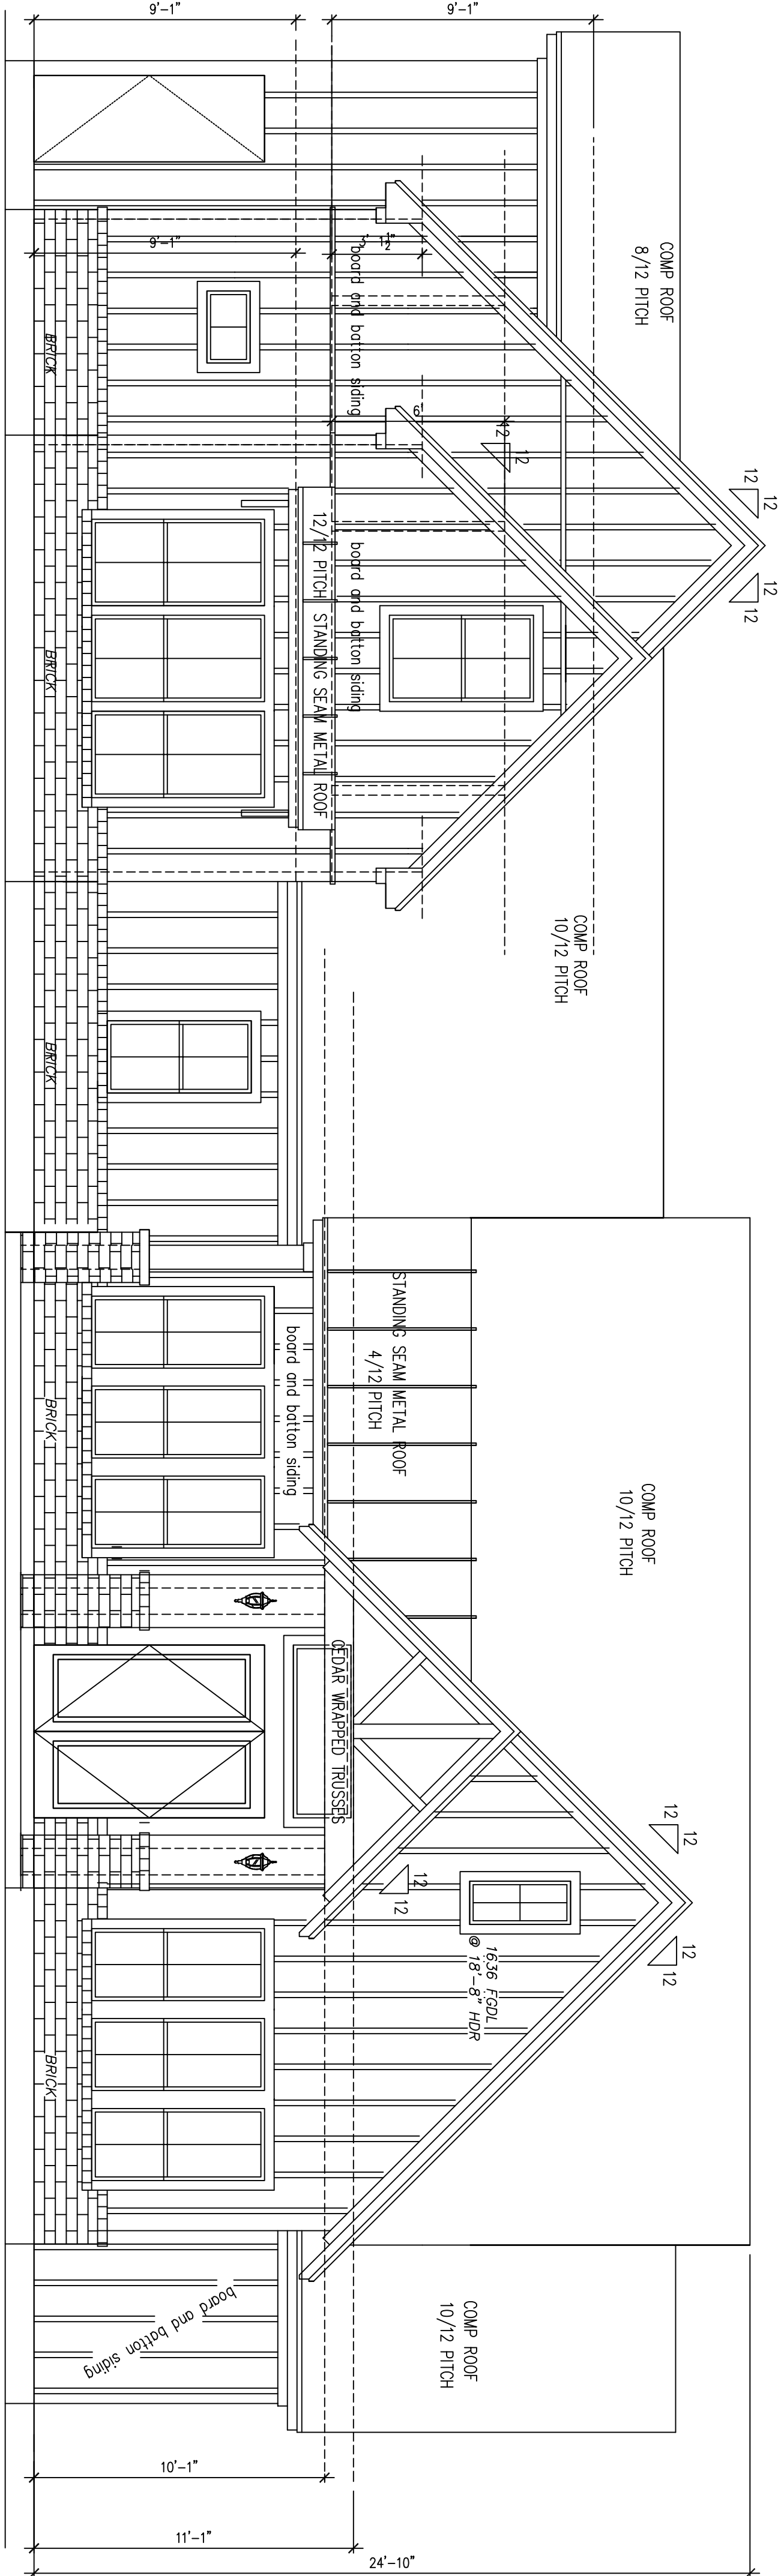

FRONT ELEVATION

SCALE: 1/4" = 1'-0"

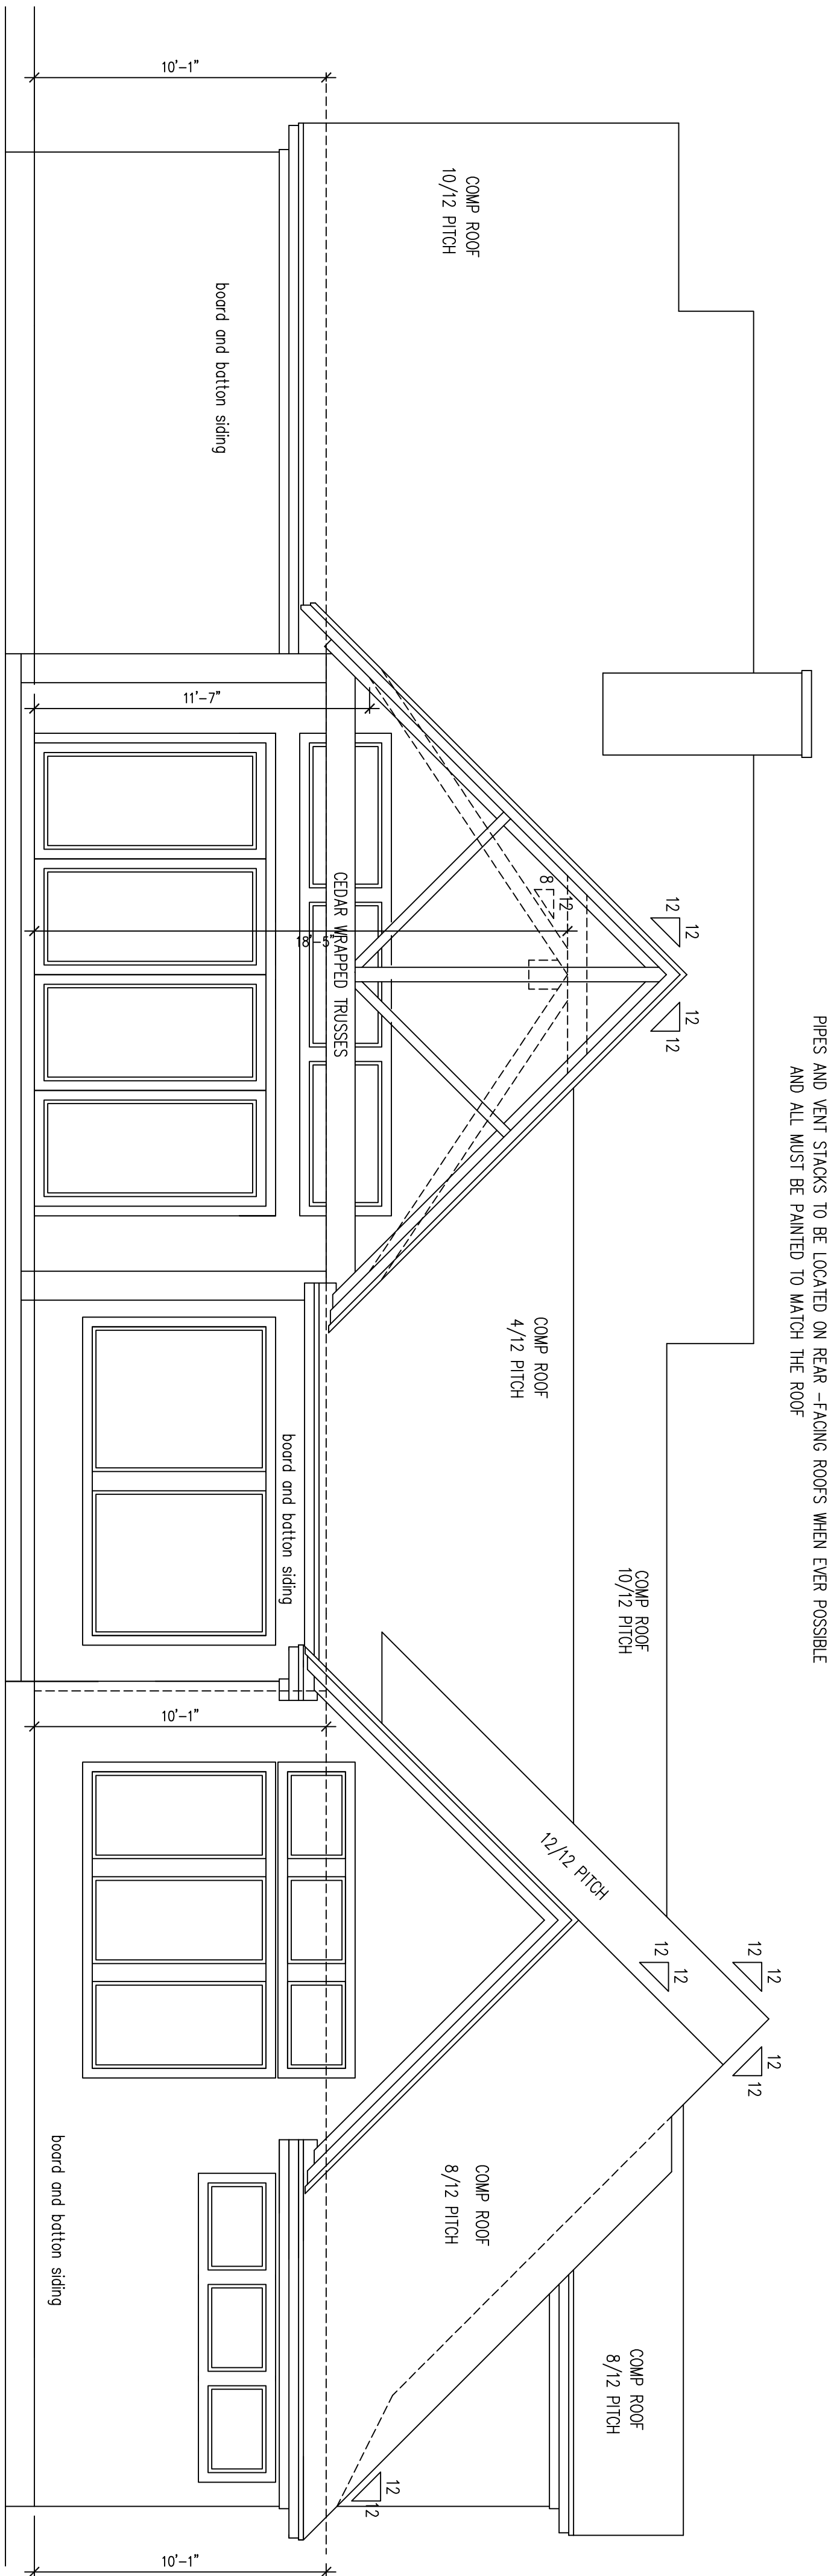

REAR ELEVATION

SCALE: 1/4" = 1'-0"

SPEC MODEL
ADDRESS
THE CEDARS

DROLLETT
DESIGNS

27427 SHADY HILLS LANDING LANE
SPRING, TEXAS 77386
OFFICE (713) 539-3921
FAX (281) 855-9733

No.	DATE	DESCRIPTION
1	DATE_1	PLAN MEETING 1
2	DATE_2	PLAN MEETING 2 (IF NEEDED)
3	DATE_3	PRE CONSTRUCTION
4	DATE_4	PRE CONSTRUCTION 2 (IF NEEDED)
5	DATE_5	REVISION 1
6	DATE_6	REVISION 2

SCALE: 1/4" = 1'-0"


DRAWN BY: WAYNE JD

CHECKED BY:

DATE: 10-06-2023


SHEET NO.

ELBV-1

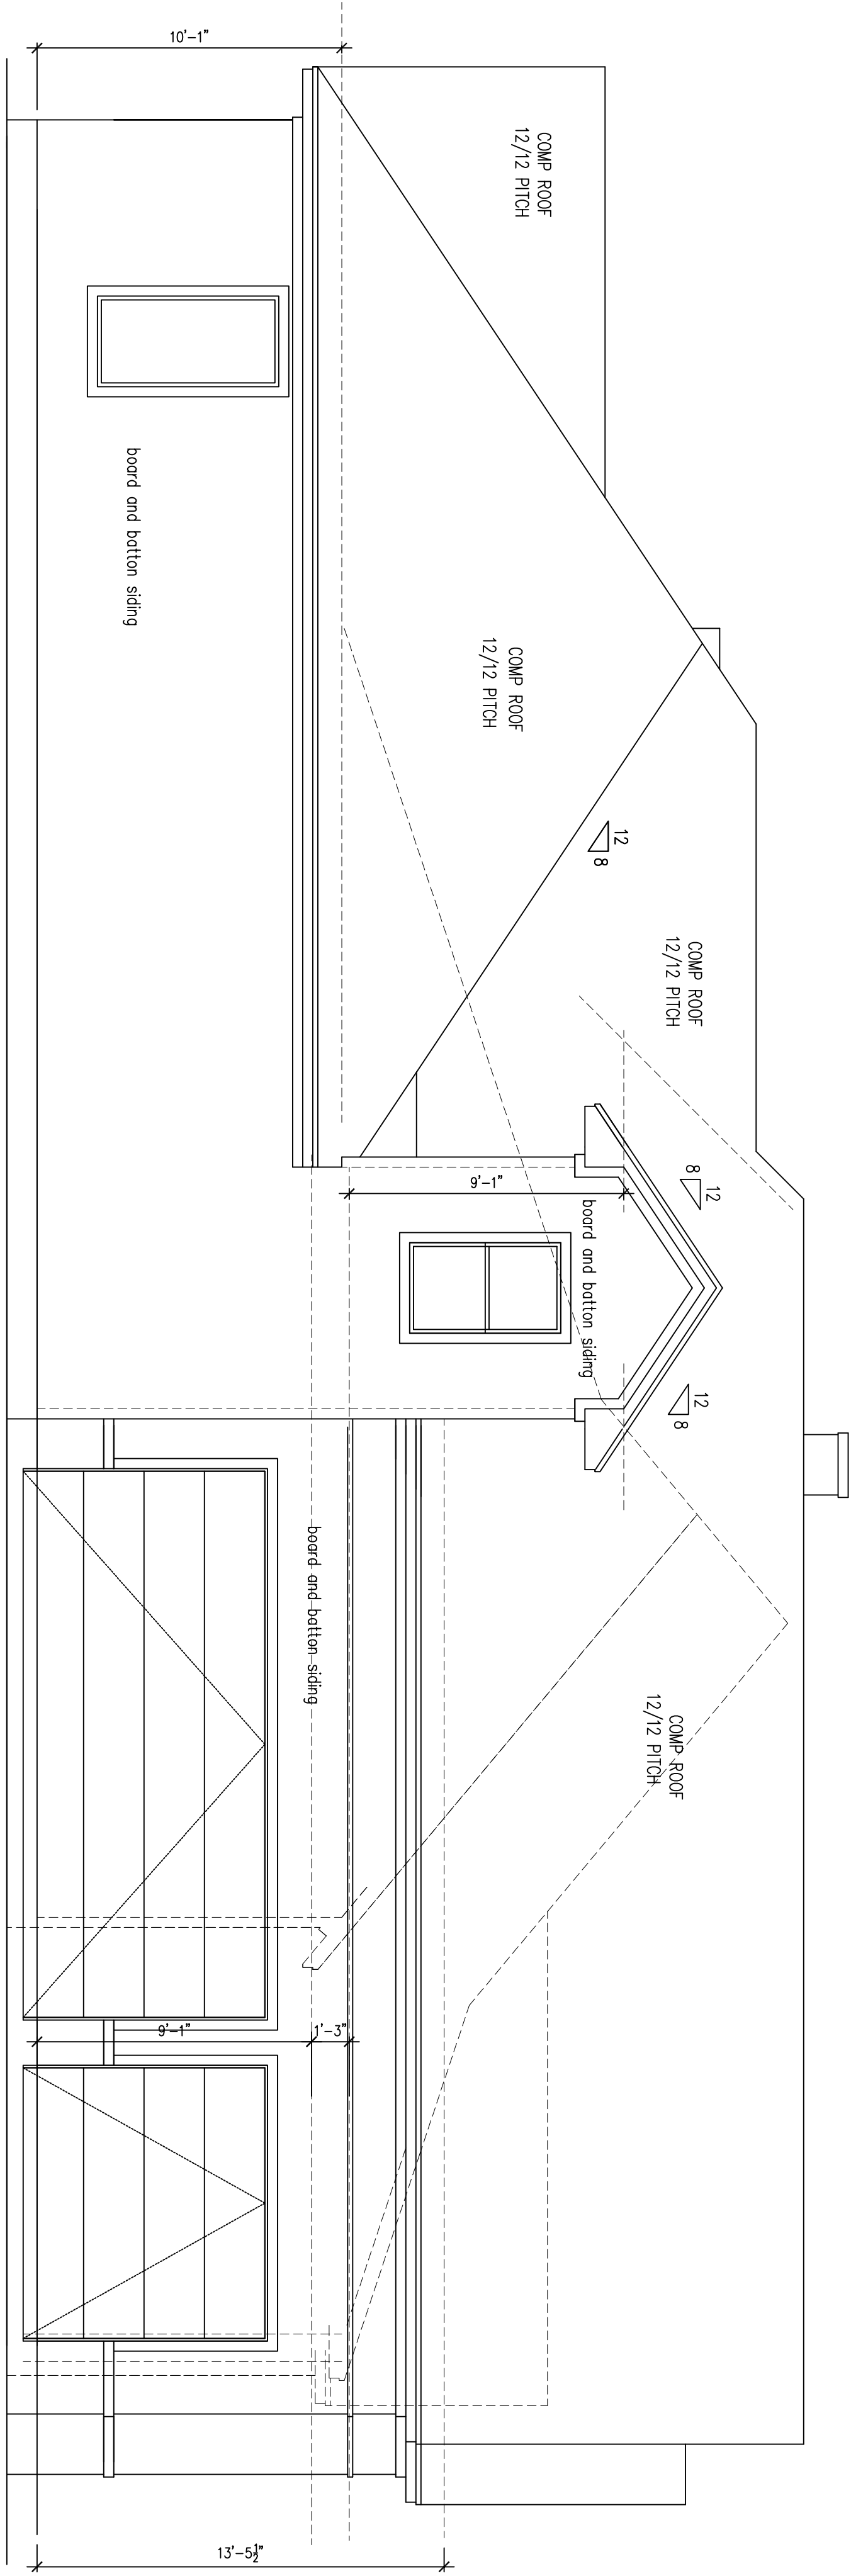

LEFT ELEVATION

SCALE: 1/4" = 1'-0"

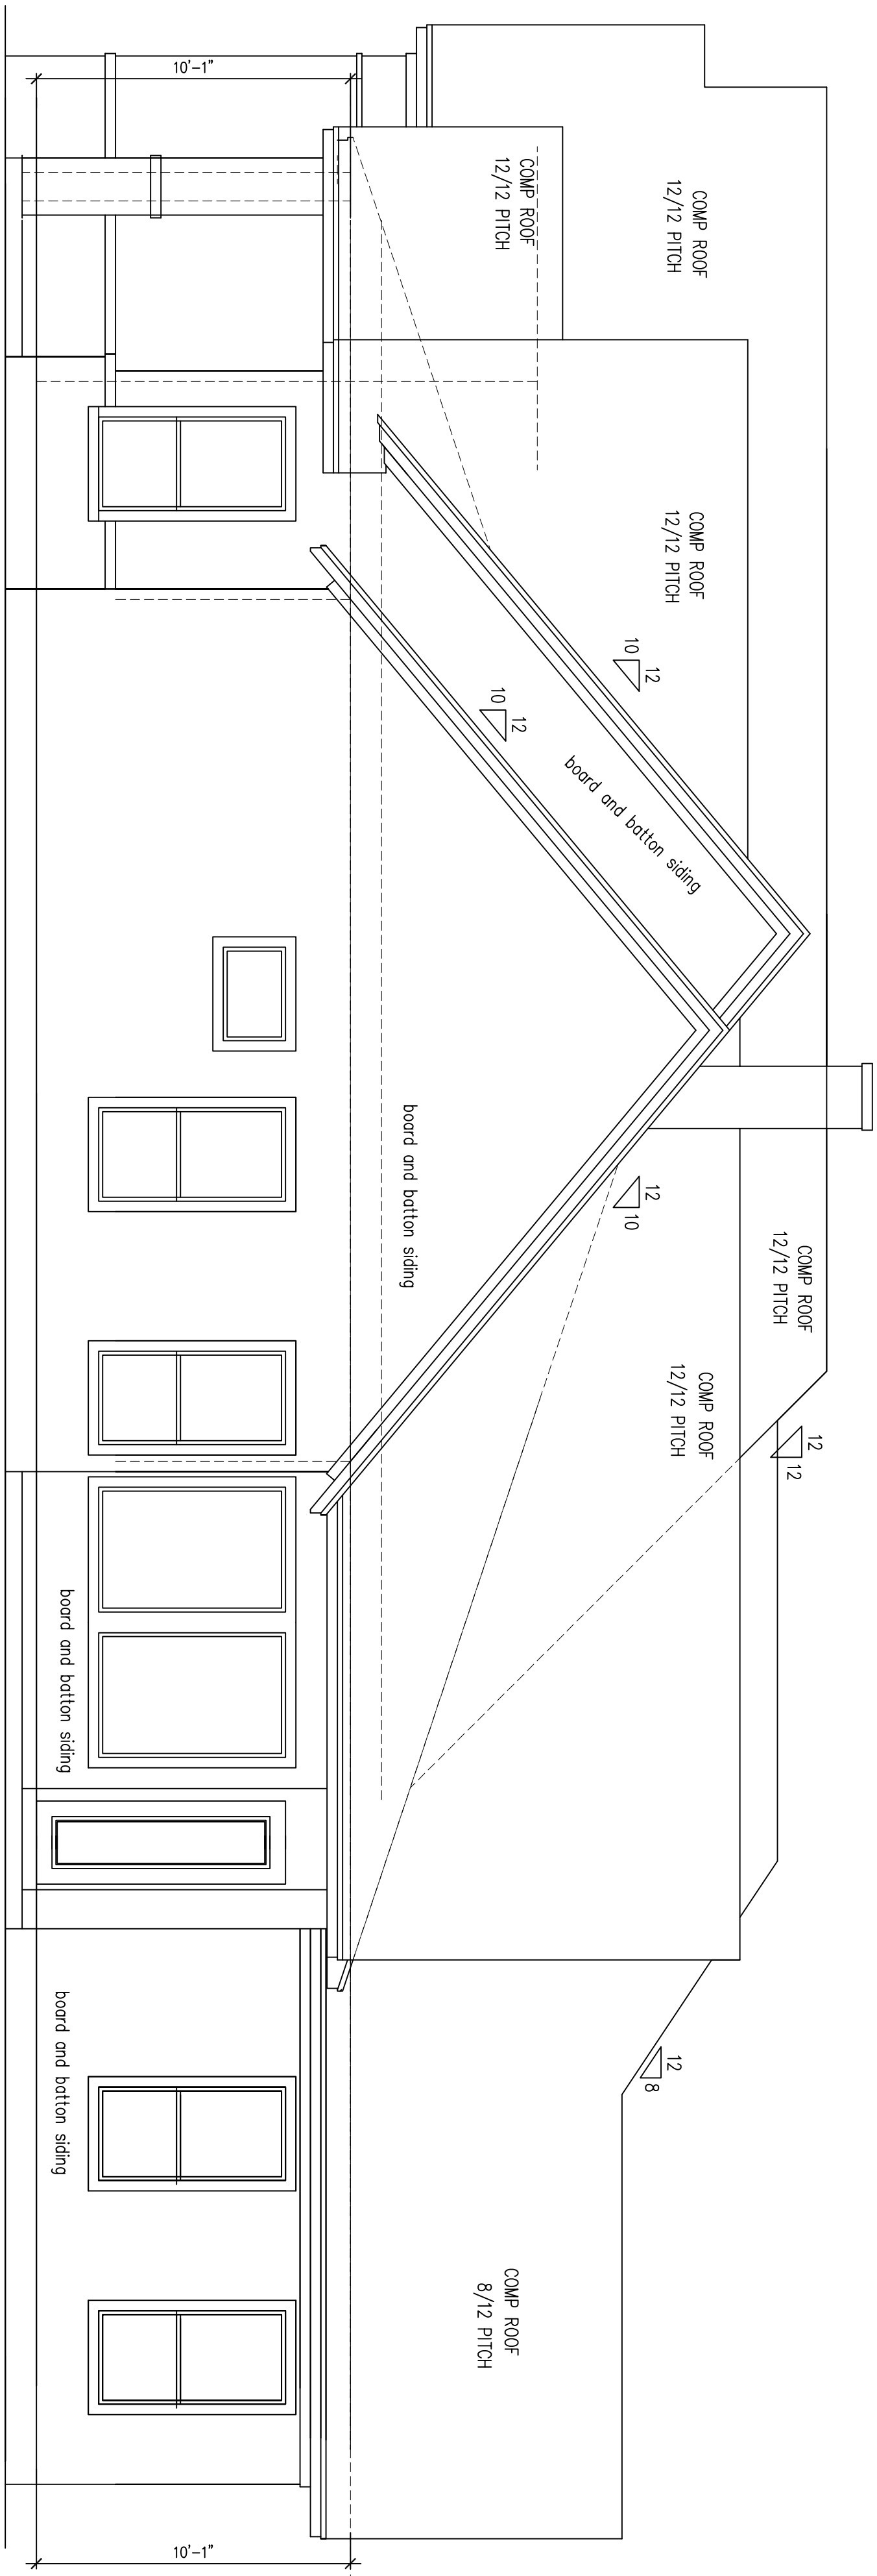

RIGHT ELEVATION

SCALE: 1/4" = 1'-0"

No.	DATE	DESCRIPTION
1	DATE_1	PLAN MEETING 1
2	DATE_2	PLAN MEETING 2 (IF NEEDED)
3	DATE_3	PRE CONSTRUCTION
4	DATE_4	PRE CONSTRUCTION 2 (IF NEEDED)
5	DATE_5	REVISION 1
6	DATE_6	REVISION 2

DROLLETT
DESIGNS

27427 SHADY HILLS LANDING LANE
SPRING, TEXAS 77386
OFFICE (713) 539-3921
FAX (281) 855-9733

SPEC MODEL
ADDRESS
THE CEDARS

SCALE: 1/4" = 1'-0"

DRAWN BY: WAYNE JD

CHECKED BY:

DATE: 10-06-2023

SHEET NO.

ELBV-2

ELECTRICAL LEGEND

(ALL RECEPTACLES TO BE TAMPER-RESISTANT)
PER 2012 IRC

110 VOLT RECEPTACLE

WATERPROOF RECEPTACLE

110 VOLT IN C.L.G.

110 VOLT W/ GROUND FAULT INTERRUPTER

220 VOLT IN FLOOR

TELEVISION ANTENNA

GAS OUTLET

HOSE BIB

TELEPHONE OUTLET

SINGLE POLE SWITCH

THREE WAY SWITCH

FOUR WAY SWITCH

DIMMER SWITCH

PUSH BUTTON

SMOKE DETECTOR

CARBON DIOXIDE DETECTOR

THERMOSTAT

DOORBELL CHIMES

CEILING MOUNTED LIGHT FIXTURE

HANGING LIGHT

LED LIGHT FIXTURE

RECESSED CAN LIGHT

WATERPROOF RECESSED CAN LIGHT

RECESSED EYEBALL SPOT LIGHT

WALL MOUNTED LIGHT FIXTURE

PORCELAIN FIXTURE W/ PULL CORD

FLOOD LIGHTS

EXHAUST FAN

EXHAUST FAN W/ LIGHT

EXHAUST FAN W/ HEAT LAMP

EXHAUST FAN W/ HEAT LAMP & L.T.

KEYLESS CEILING MOUNTED LIGHT FIXTURE

UNDER COUNTER LIGHT

ZONE SENSOR


CEILING FAN

CEILING FAN W/ LIGHT

CEILING LIGHT W/ FUTURE FAN

2X4 FLUORESCENT LIGHT

1X4 FLUORESCENT LIGHT

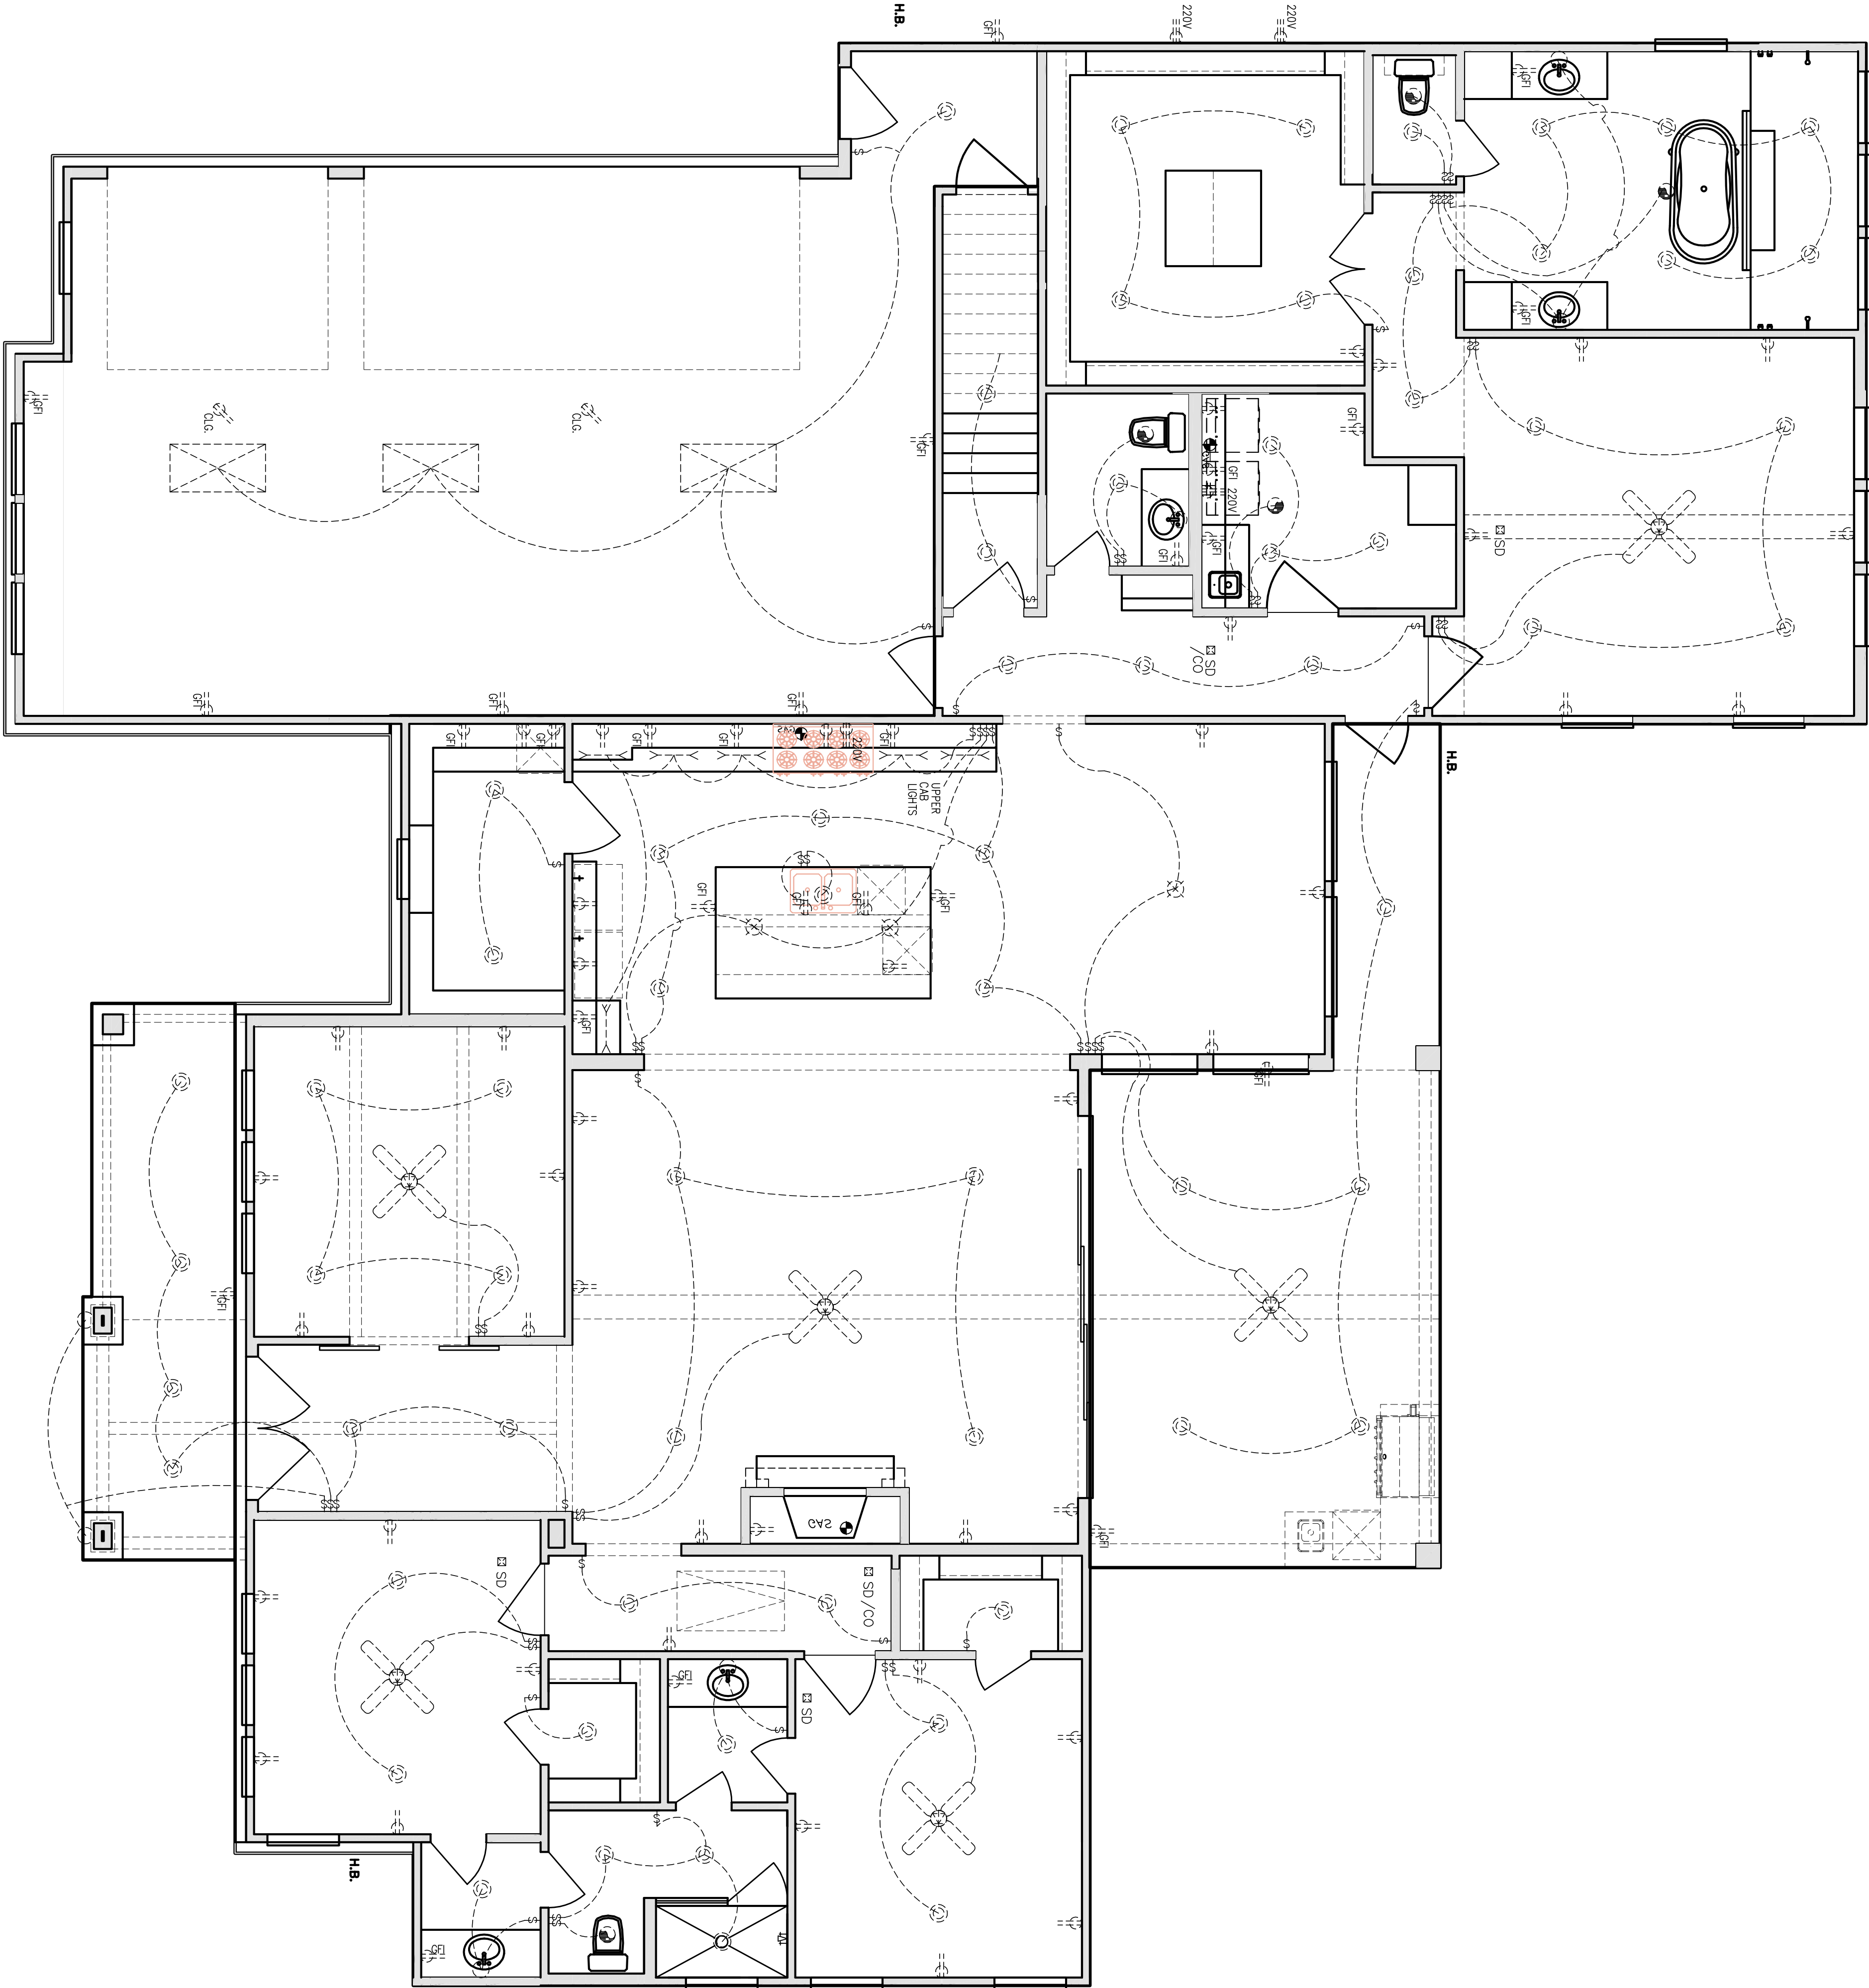

No.	DATE	DESCRIPTION
1	DATE_1	PLAN MEETING 1
2	DATE_2	PLAN MEETING 2 (IF NEEDED)
3	DATE_3	PRE CONSTRUCTION
4	DATE_4	PRE CONSTRUCTION 2 (IF NEEDED)
5	DATE_5	REVISION 1
6	DATE_6	REVISION 2

DROLLETT
DESIGNS

27427 SHADY HILLS LANDING LANE
SPRING, TEXAS 77386
OFFICE (713) 539-3921
FAX (281) 855-9733

SPEC MODEL
ADDRESS
THE CEDARS

SCALE:
1/4" = 1'-0"


DRAWN BY:
WAYNEJD

CHECKED BY:

DATE:
10/06/2023

SHEET NO.

ELEC

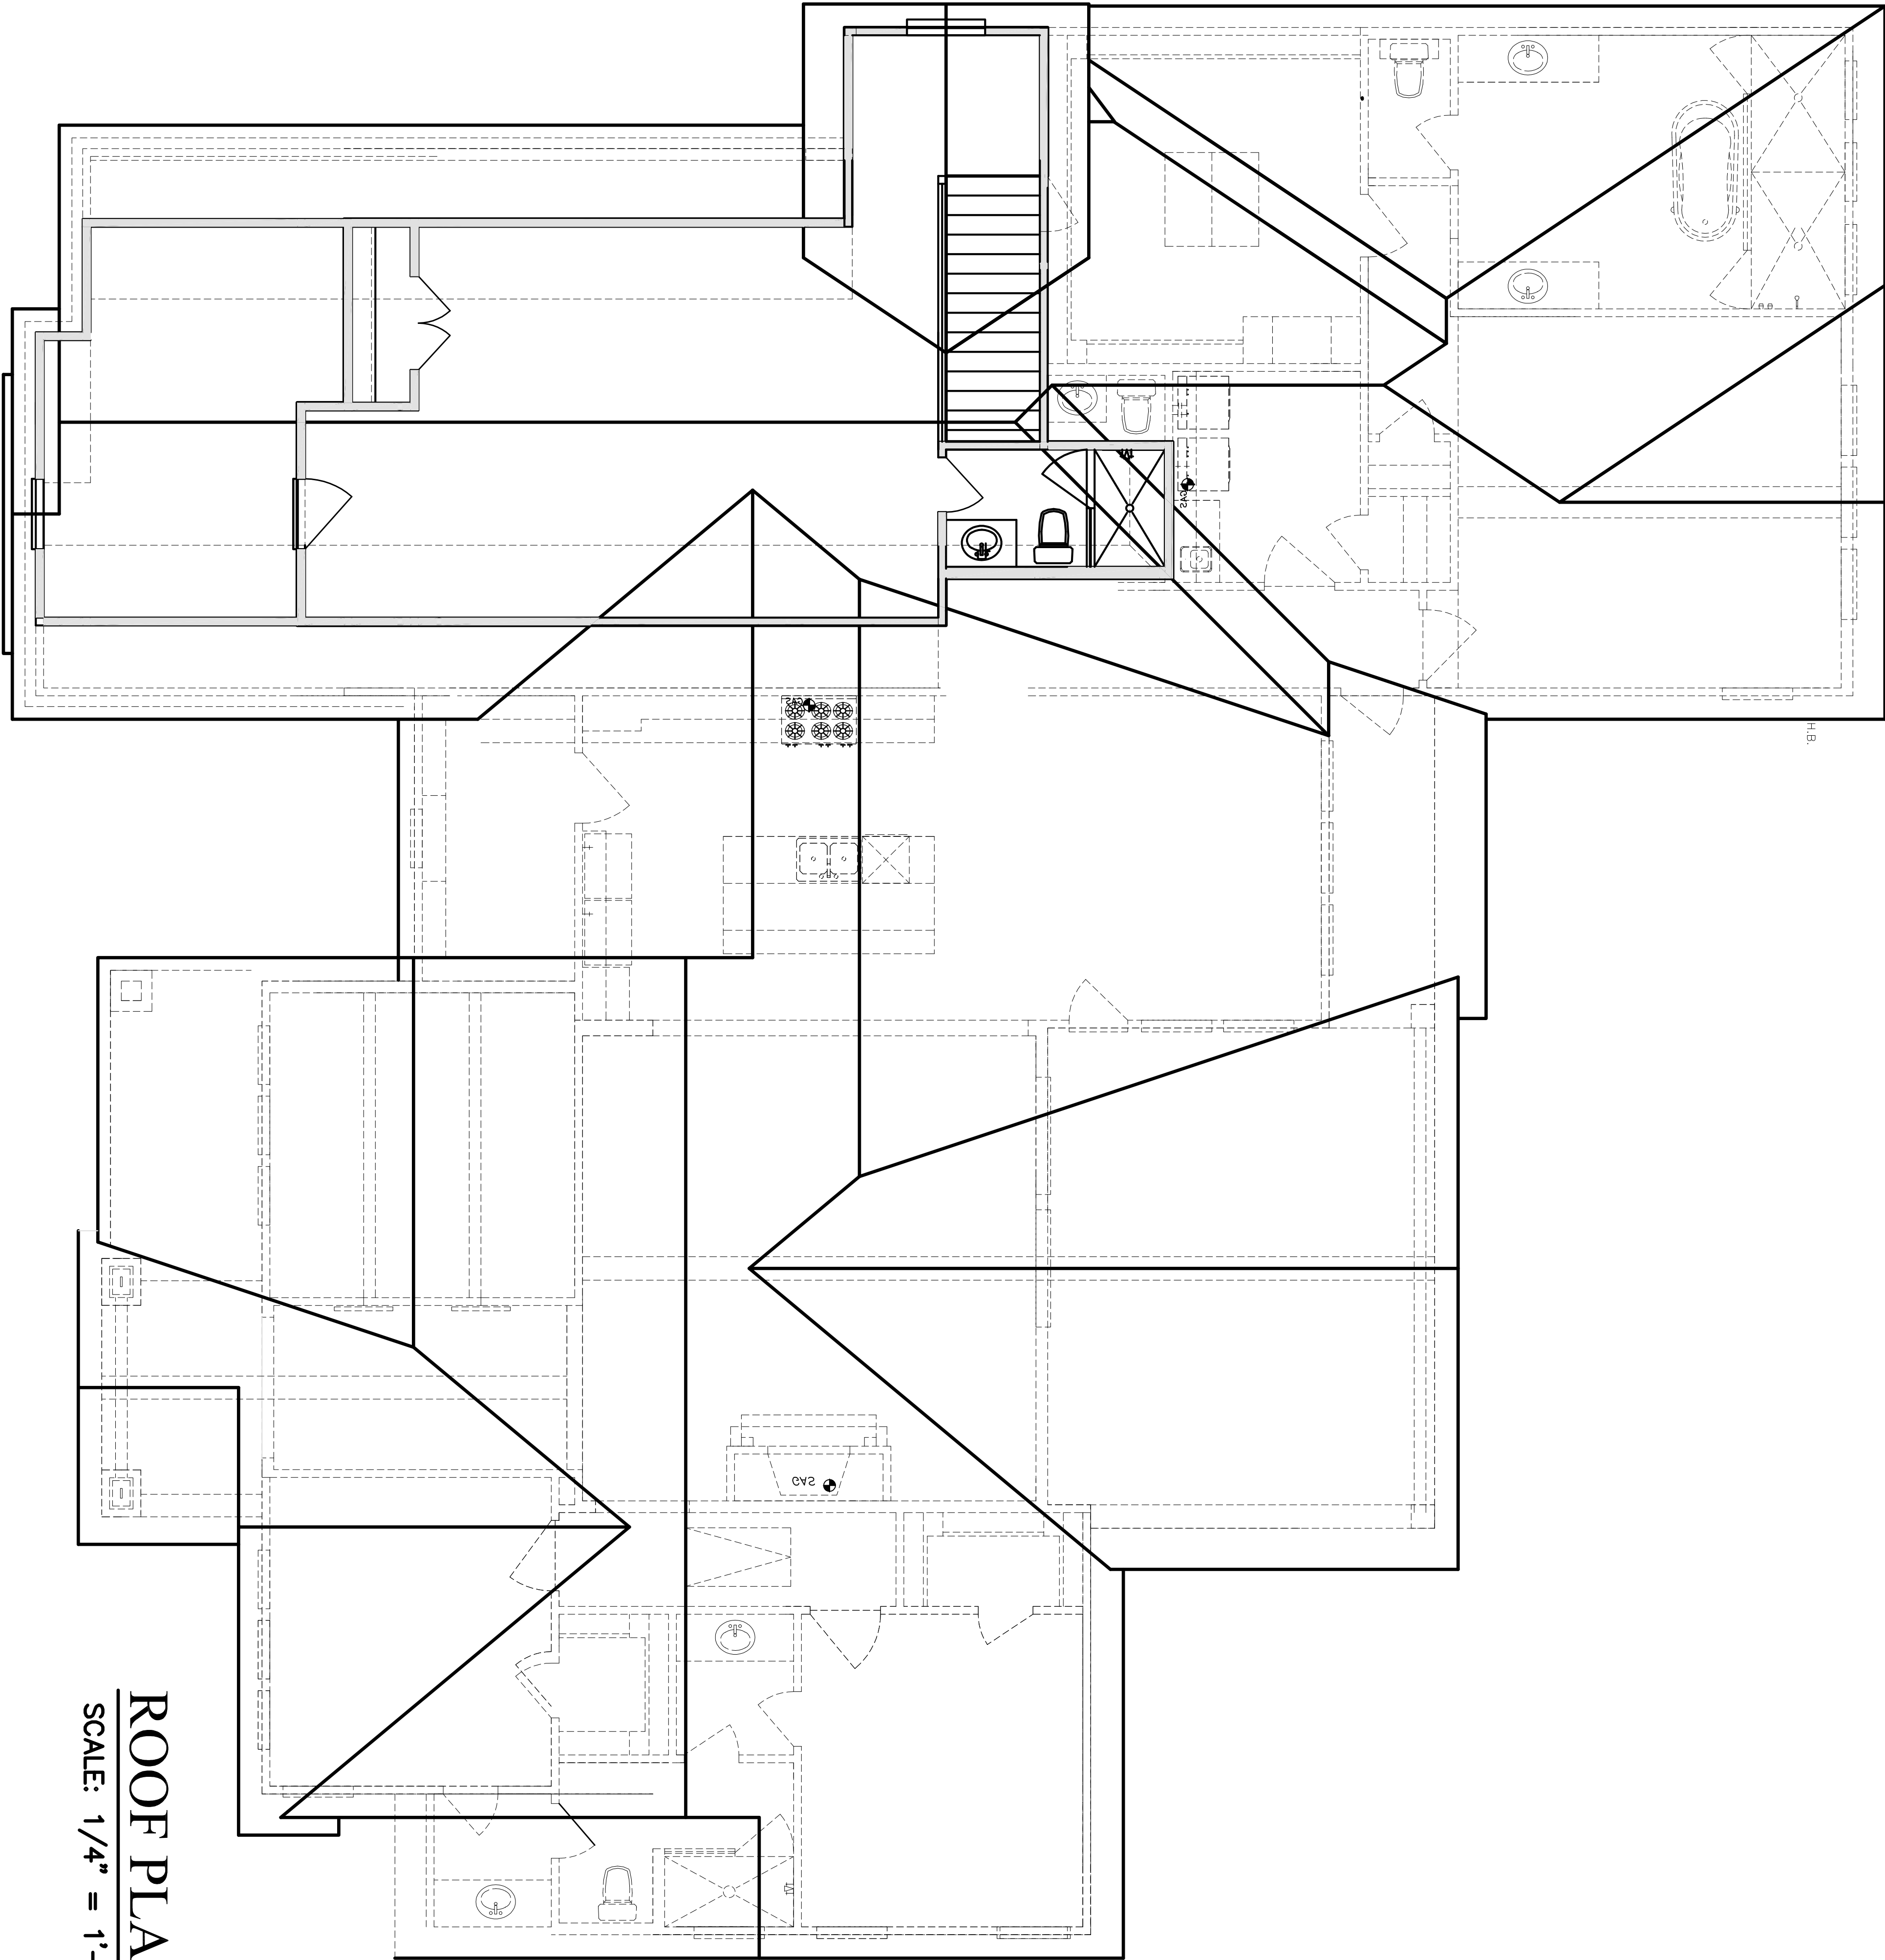

ROOF PLAN
SCALE: 1/4" = 1'-0"

No.	DATE	DESCRIPTION
1	DATE_1	PLAN MEETING 1
2	DATE_2	PLAN MEETING 2 (IF NEEDED)
3	DATE_3	PRE CONSTRUCTION
4	DATE_4	PRE CONSTRUCTION 2 (IF NEEDED)
5	DATE_5	REVISION 1
6	DATE_6	REVISION 2

SCALE:	1/4" = 1'-0"
DRAWN BY:	WAYNEJD
CHECKED BY:	
DATE:	10-06-2023
SHEET NO.	ROOF

DROLLETT
DESIGNS

27427 SHADY HILLS LANDING LANE
SPRING, TEXAS 77386
OFFICE (713) 539-3921
FAX (281) 855-9733

SPEC MODEL
ADDRESS
THE CEDARS