

2017 NEC

ELECTRICAL NOTES:

1. ELECTRICAL INSTALLATION TO BE IN ACCORDANCE WITH THE NATIONAL ELECTRICAL CODE NFPA-70
2. THE ELECTRICAL CONTRACTOR IS RESPONSIBLE FOR OBTAINING ELECTRICAL PERMITS AND INSPECTION.
3. CONVENIENCE RECEPTACLE - MOUNT AT 12" A.F.F. UNLESS NOTED OTHERWISE.
4. MICROWAVE-OVEN TO HAVE SEPARATE 20AMP SINGLE RECEPTACLE AT 78" A.F.F.
5. BATHROOM RECEPTACLE - GFI MOUNT 40" A.F.F.
6. RECEPTACLES IN THE GARAGE TO BE GFI UNLESS NOTED OTHERWISE.
7. EXTERIOR RECEPTACLES TO BE GFI AND WEATHER PROTECTED.
8. WASHER - DRYER TO HAVE SEPARATE 20AMP DUPLEX RECEPTACLE AT 44" A.F.F.
9. TELEPHONE OUTLETS - PROVIDE BOX (MOUNT AT 12" A.F.F. UNLESS NOTED OTHERWISE). COVER PLATE 4/0 WIRE. TERMINATE NEAR PANEL.
10. KITCHEN COUNTER AND REFRIGERATOR RECEPTACLES AND APPLIANCE SWITCHES MOUNT AT 44" A.F.F.
11. SWITCHED - MOUNT AT 54" A.F.F.
12. ATTIC LIGHT SWITCH MOUNT AT 84" A.F.F.
13. SMOKE DETECTORS TO BE INTERCONNECTED & HAVE BATTERY BACKUP

ELECTRICAL LEGEND:

\$ SINGLE POLE SWITCH

\$ THREE-WAY SWITCH

110V DUPLEX RECEPTICLE

SURFACE MOUNTED LIGHT

CIR. FAN

CIR. FAN

CATS/TV

CABLE TV & TELEPHONE

SM

SMOKE DETECTOR

COX

CARBON MONOXIDE DETECTOR

CHIMES

DOOR BELL CHIMES

DB

DOOR BELL

GAS

GAS OUTLET

220v

220V OUTLET

WALL MOUNT FIXTURE

RECESSED LIGHT FIXTURE

4" RECESSED MRI6 LV FIXTURE

4" MRI6 RECESS LV DIRECTIONAL


WP GFI

WEATHER PROOF GROUND FAULT INTERFACE

CEILING FAN W/ LIGHT

CEILING FAN W/O LIGHT

***PLUGS IN BASEBOARD ***
SEE BUILDER FOR HEIGHT
UNLESS OTHERWISE NOTED

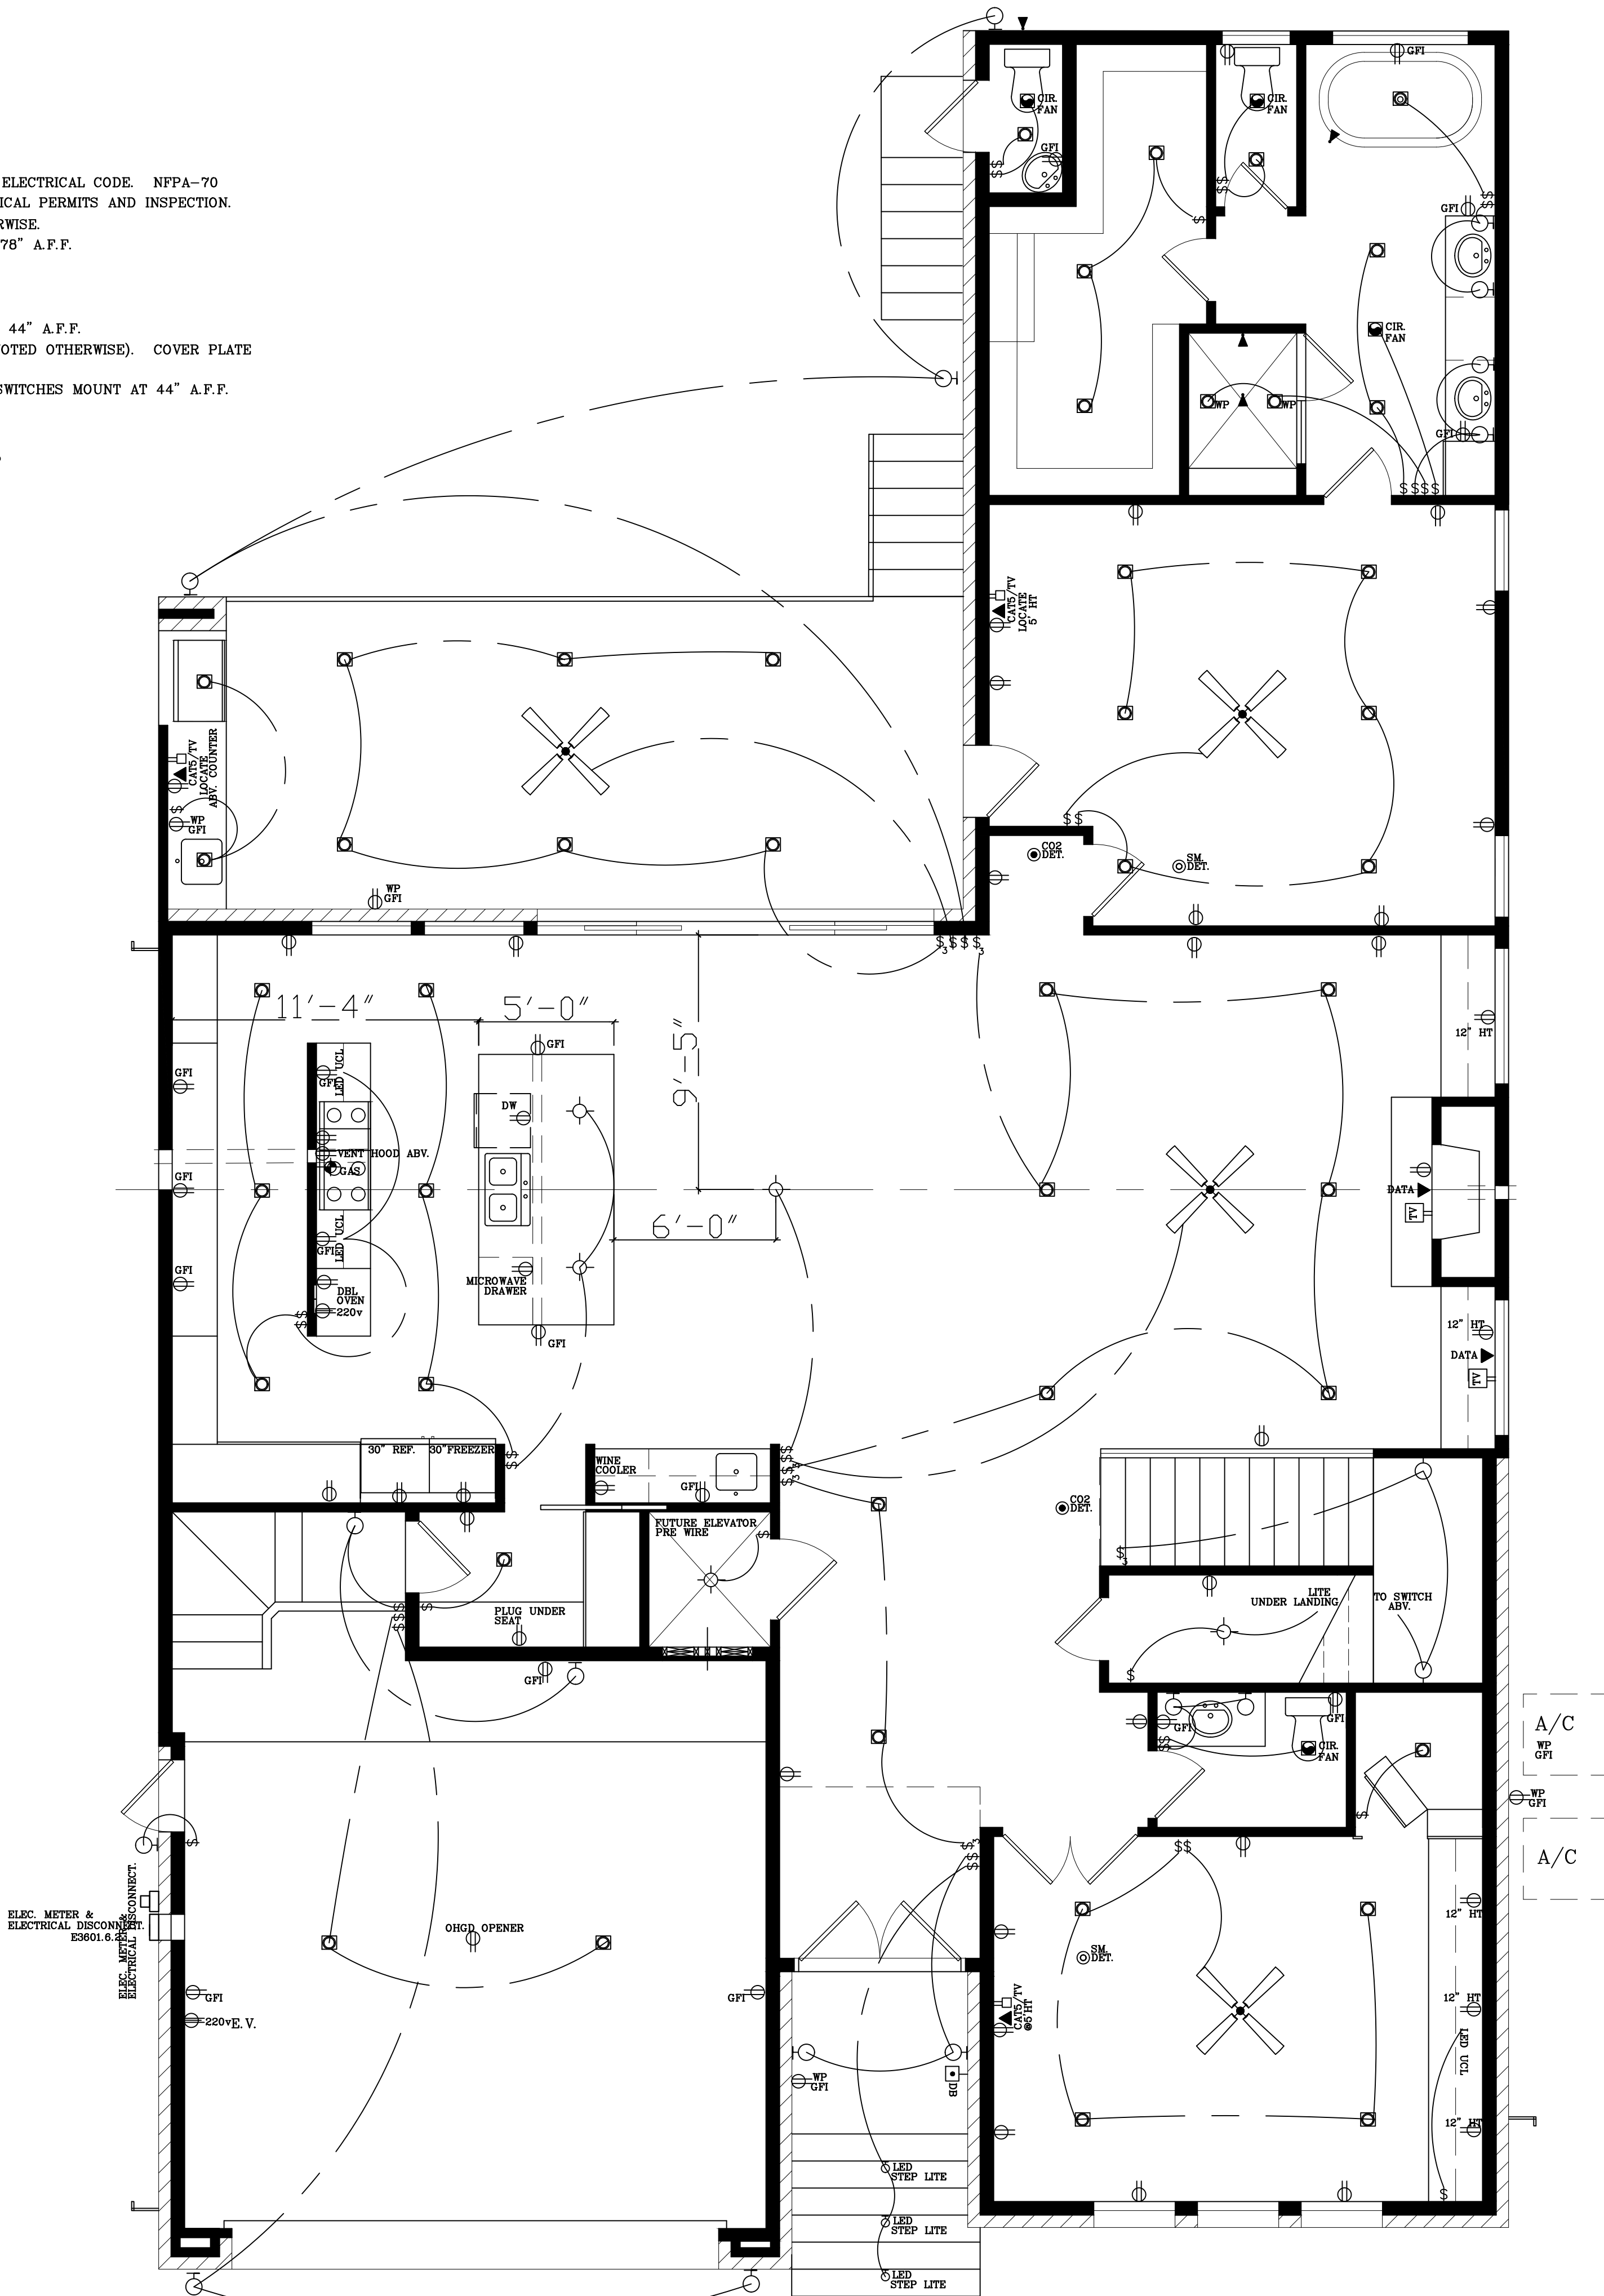

FIRST FLOOR ELEC. PLAN
SCALE: 1/4" = 1'-0"



4800 TAMARISK
020600

TX

4800 TAMARISK LN.
BELLATRE 77401

LINEA
DESIGN STUDIO

2020 Richmond Ave, Ste 202 Houston, TX T. 713.589.2335
www.lineadesignstudio.com

JOB. NO.
ISSUE DATE

C.O.:
CHECK BY:

5441

SHEET NO.
E.001